


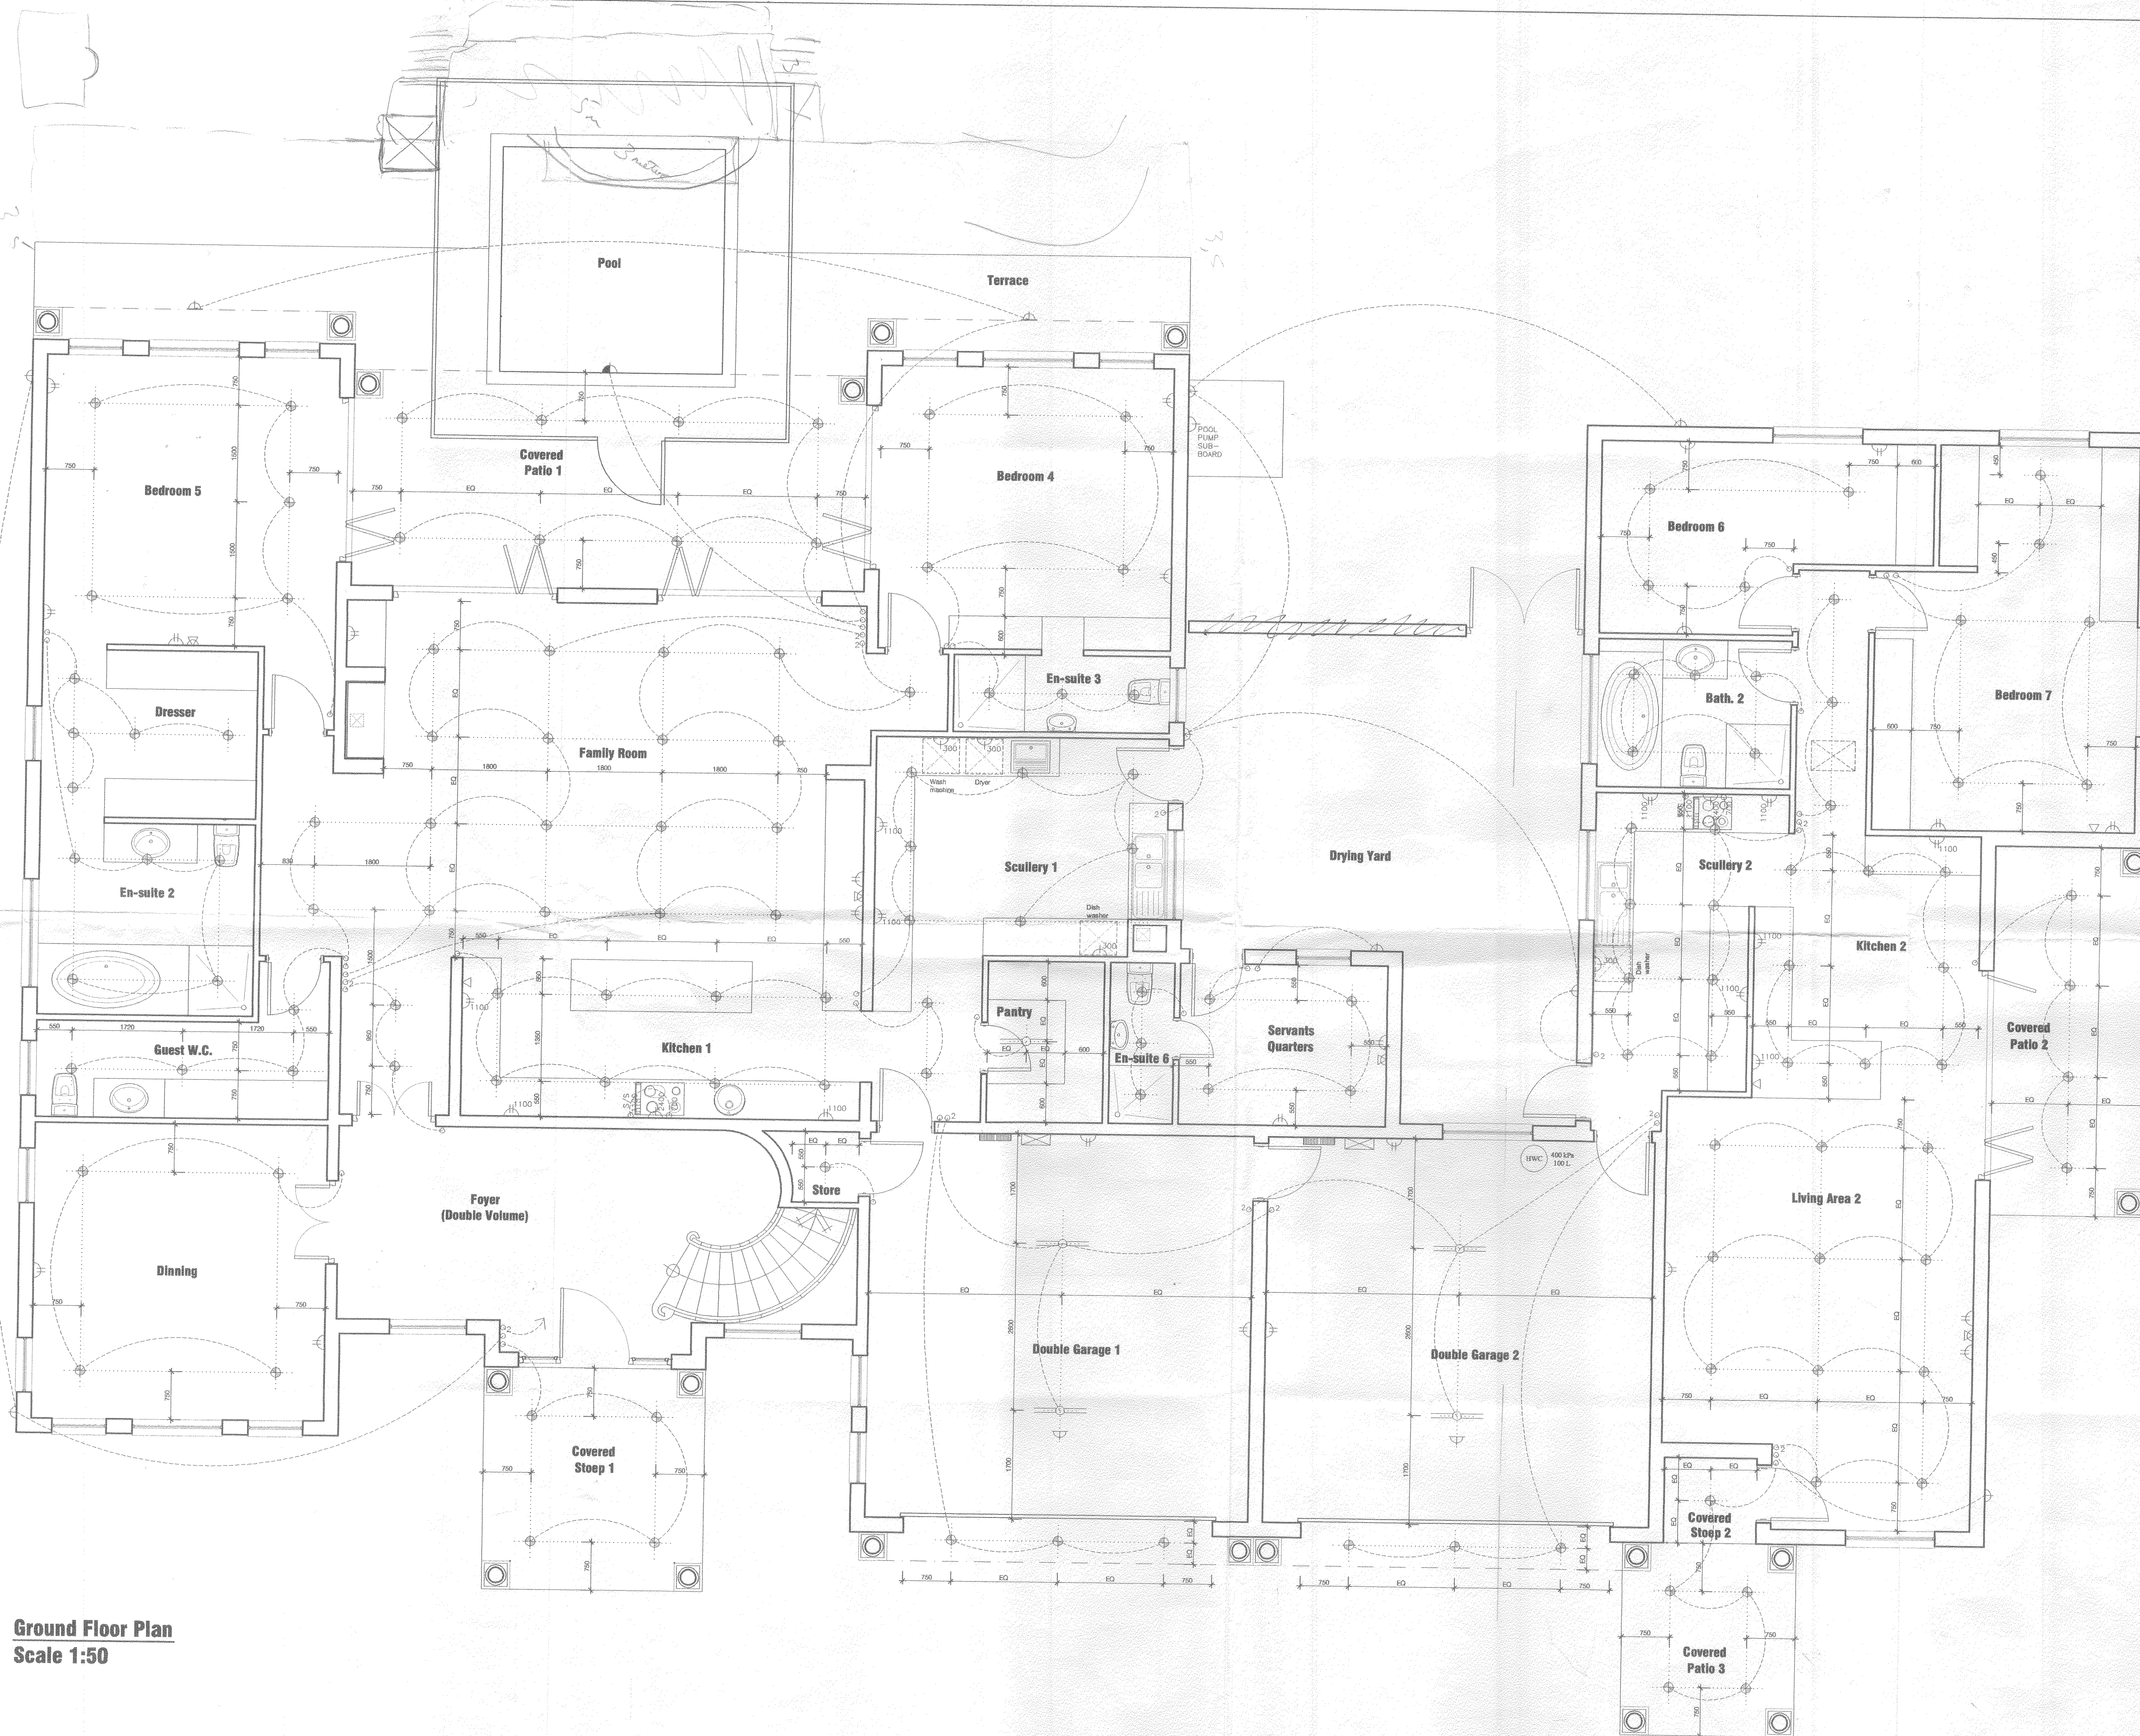

Ground Floor Plan
Scale 1:50

ELECTRICAL SYMBOLS

○	SINGLE LIGHT SWITCH
○ ²	2-WAY LIGHT SWITCH
○ ³	3-WAY LIGHT SWITCH
○ ^D	DIMMER SWITCH
○ ^R	FAN RESISTOR SWITCH
○ ^T	THERMOSTAT SWITCH FOR UNDER-TILE/CARPET HEATING
○ ^{S/S}	OVEN AND HOB SWITCH
○ ^L	LIGHT POINT
⏏	SINGLE PLUG POINT
⏏ ^S	SHAVER PLUG POINT
⏏ ^{HT}	HEATED TOWEL POINT
⏏	DOUBLE PLUG POINT
⏏ ^C	DEDICATED COMPUTER DOUBLE PLUG
⏏ ^{PH}	PANEL HEATER
⏏ ^U	OVEN POINT
⏏ ^H	HOB POINT
⏏	WALL LIGHT
⏏ ^{L/S}	WALL LIGHT WITH LIGHT-SENSITIVE SWITCH
⏏	POOL LIGHT
⏏	DOUBLE FLOURESCENT LIGHT
⏏	CEILING LIGHT
⏏	LOW VOLTAGE LIGHT
⏏	RECESSED LIGHT
⏏	AIPHONE
⏏	AIPHONE INTERCOM
⏏	TELEPHONE POINT
⏏	TELEVISION POINT
⏏	CEILING FAN
⏏	DISTRIBUTION BOARD
⏏	METER BOARD
⏏ ^{AC}	AIRCONDITIONING UNIT
⏏ ^{EX}	EXTRACTOR FAN
⏏ ^{HWC}	HOTWATER CYLINDER
⏏	CEILING TRAP-DOOR
⏏	ALARM CONTROL PANEL
⏏	ALARM SENSOR
⏏	SPEAKER POINT
⏏	STEP LIGHT
⏏	WATERPROOF LIGHT
⏏	POOL PUMP
⏏	WATERPROOF DOUBLE PLUG POINT
⏏	CONDUIT WITH SIZE
⏏ ^{BL}	BED LAMP LIGHT POINT (300HIGH) WITH SWITCH (1000HIGH)
⏏	FLOOR LIGHT
⏏ ^{EX/HEATER}	EXTRACTOR FAN & HEATER COMBINATION

MANTIS
ARCHITECTURE
INTERIOR
DESIGN

11 ALBANY ROAD, FRESNAYE 9005
Tel: 021 434-4111 Fax: 021 434-9009
E-MAIL: mantis@icon.co.za

- ALL DRAWINGS ARE COPYRIGHT AND REMAIN THE PROPERTY OF MANTIS DESIGN.
- ALL BUILDING WORK TO BE EXECUTED ACCORDING TO NATIONAL BUILDING REGULATIONS.
- ALL DIMENSIONS AND LEVELS TO BE CHECKED ON SITE PRIOR TO CONSTRUCTION.
- ALL SITE REVISIONS TO BE CONFIRMED WITH MANTIS DESIGN.

Klein Zevenwacht
Wine and Equestrian Estate
House Marais R
on Erf 16288 at 9 Brut Close

WORKING DRAWINGS	DRAWN HJ	DATE 26 May 2006
Electrical Layout: Ground Floor	CHECKED	REVISION
	SCALE 1:50	

DRAWING NUMBER
M4.05.W-11