


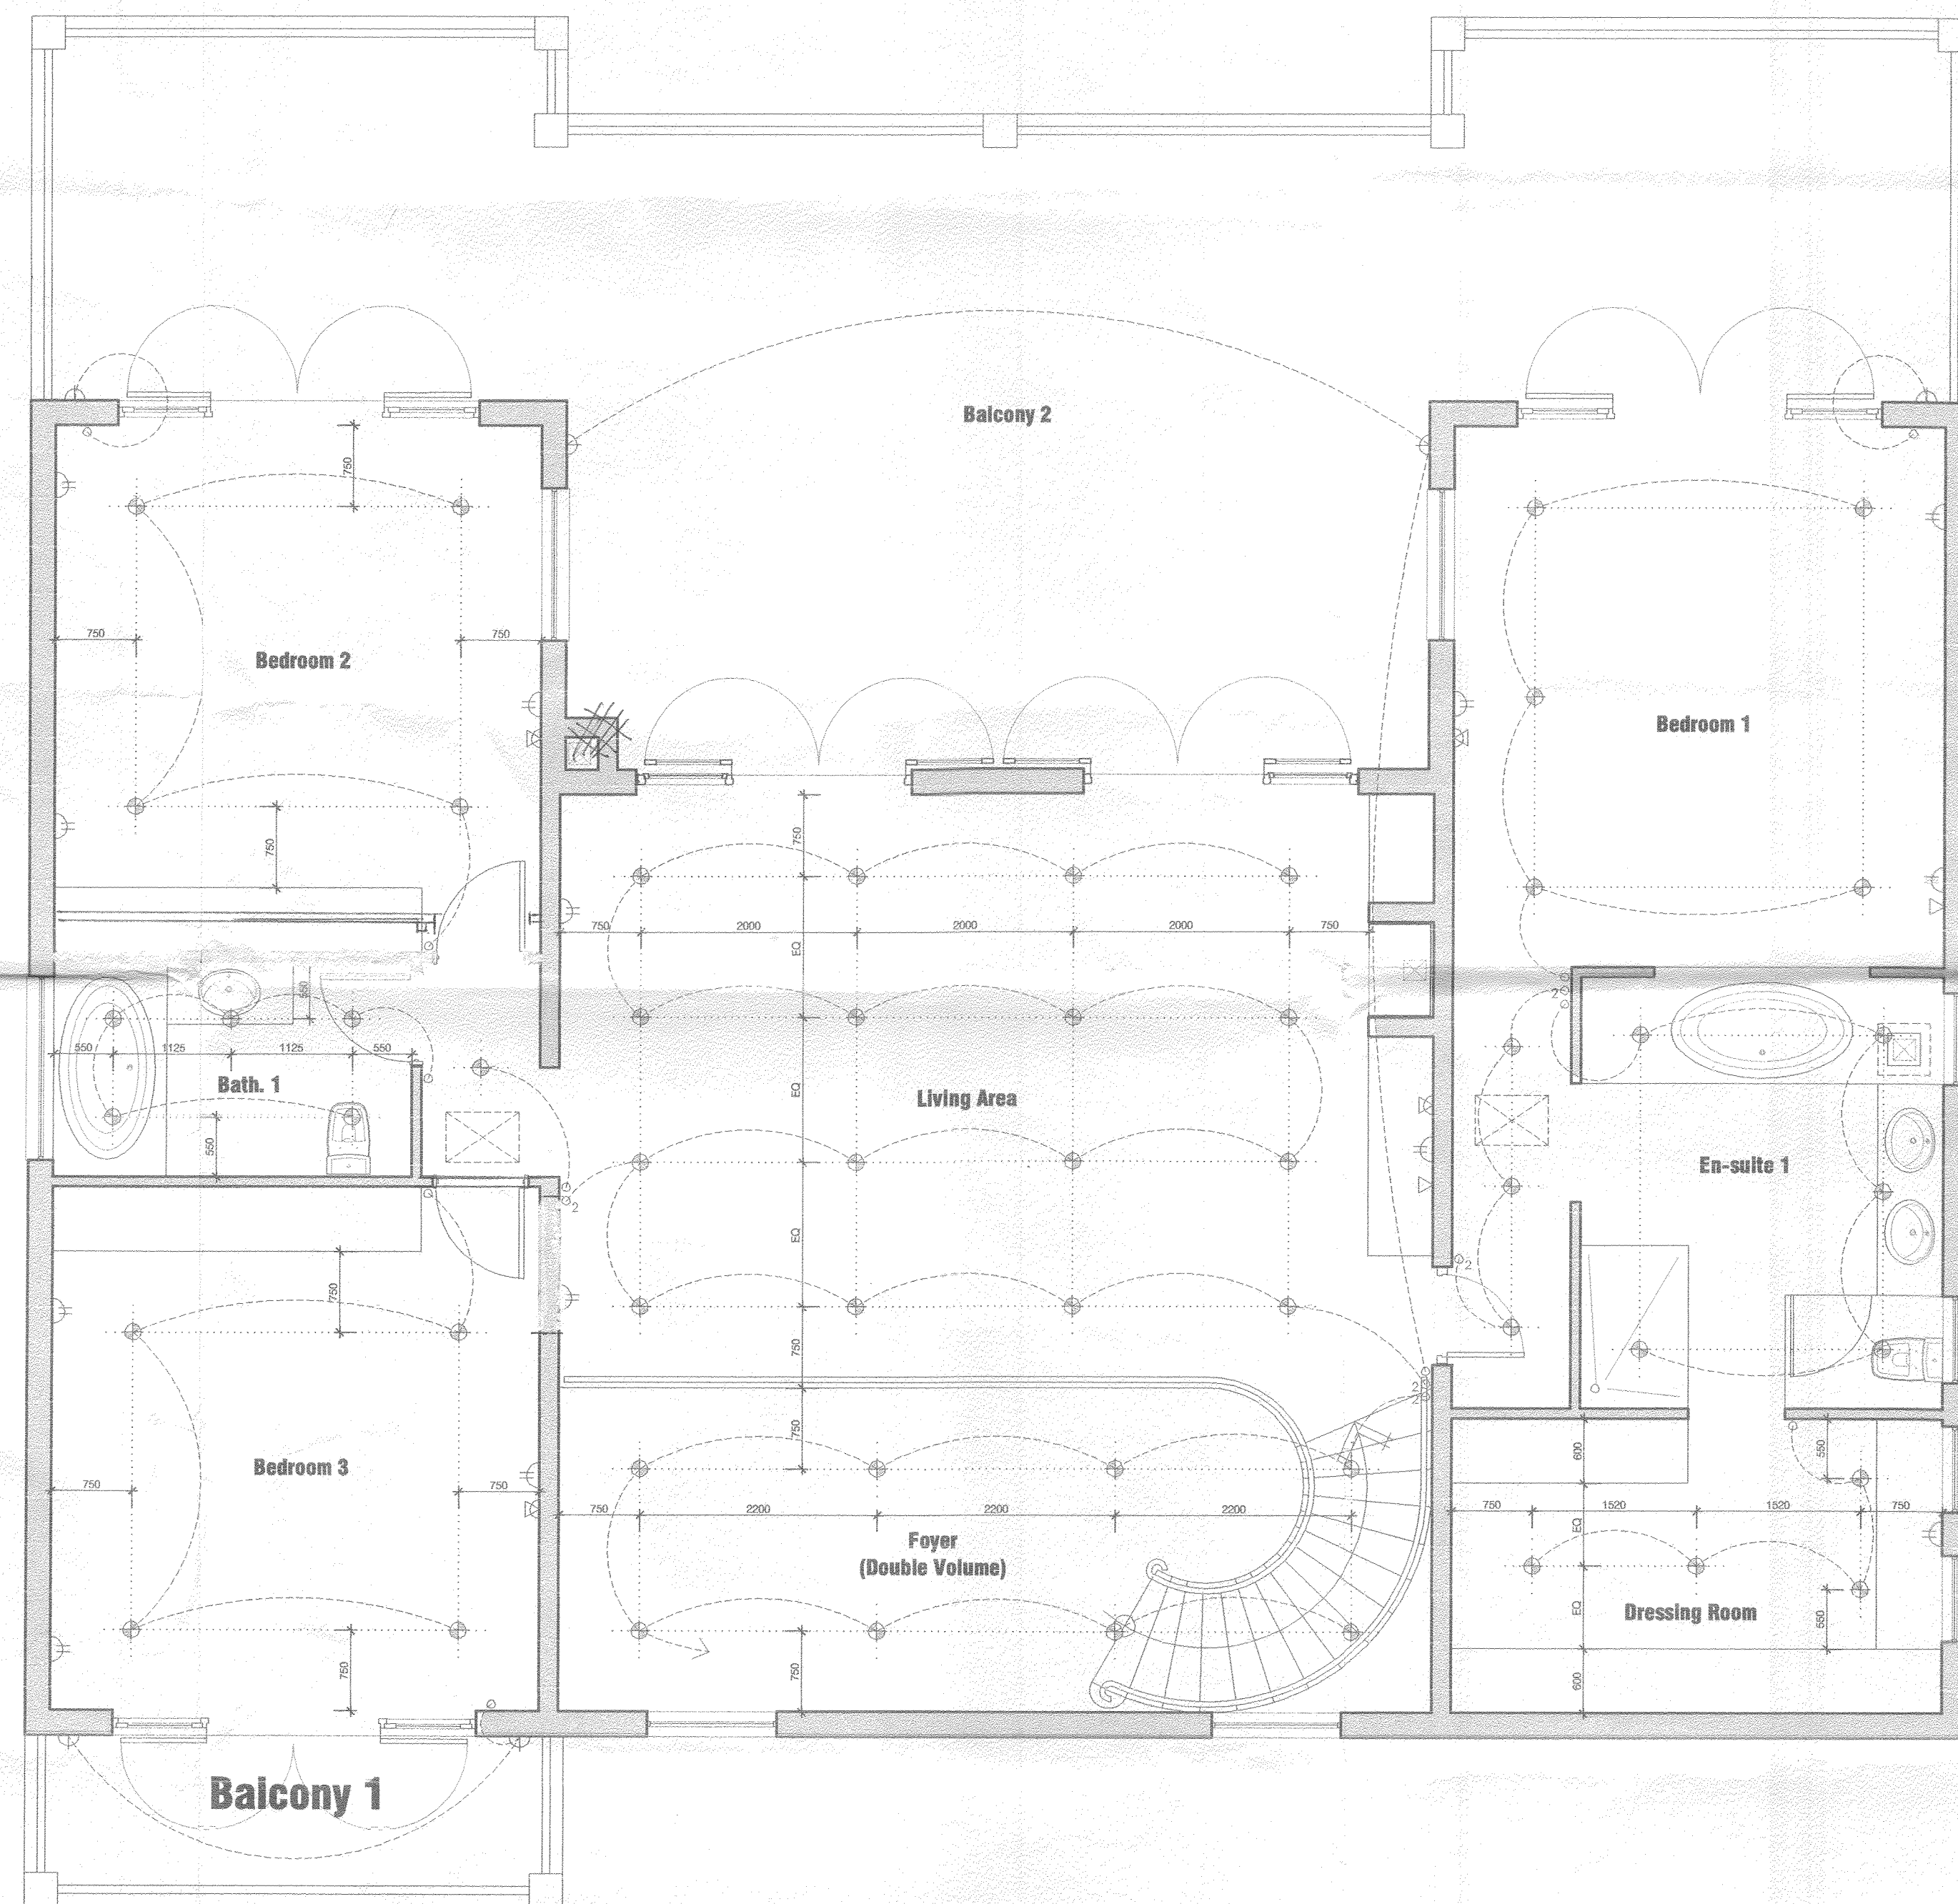

First Floor Plan
Scale 1:50

ELECTRICAL SYMBOLS	
	SINGLE LIGHT SWITCH
	2-WAY LIGHT SWITCH
	3-WAY LIGHT SWITCH
	DIMMER SWITCH
	FAN RESISTOR SWITCH
	THERMOSTAT SWITCH FOR UNDER-TILE/CARPET HEATING
	OVEN AND HOB SWITCH
	LIGHT POINT
	SINGLE PLUG POINT
	SHAVER PLUG POINT
	HEATED TOWEL POINT
	DOUBLE PLUG POINT
	DEDICATED COMPUTER DOUBLE PLUG
	PANEL HEATER
	OVEN POINT
	HOB POINT
	WALL LIGHT
	WALL LIGHT WITH LIGHT-SENSITIVE SWITCH
	POOL LIGHT
	DOUBLE FLOURESCENT LIGHT
	CEILING LIGHT
	LOW VOLTAGE LIGHT
	RECESSED LIGHT
	AIPHONE
	AIPHONE INTERCOM
	TELEPHONE POINT
	TELEVISION POINT
	CEILING FAN
	DISTRIBUTION BOARD
	METER BOARD
	AIRCONDITIONING UNIT
	EXTRACTOR FAN
	HOT WATER CYLINDER
	CEILING TRAP-DOOR
	ALARM CONTROL PANEL
	ALARM SENSOR
	SPEAKER POINT
	STEP LIGHT
	WATERPROOF LIGHT
	POOL PUMP
	WATERPROOF DOUBLE PLUG POINT
	CONDUIT WITH SIZE
	BED LAMP LIGHT POINT (300HIGH) WITH SWITCH (1000HIGH)
	FLOOR LIGHT
	EXTRACTOR FAN & HEATER COMBINATION

ARCHITECTURE
INTERIOR
FURNITURE
DESIGN

11 ALGARVE ROAD, FRESNAY, 8005
Tel: 021 434-9111 • Fax: 021 434-9009
E-Mail: mantis@icon.co.za

- * ALL DRAWINGS ARE COPYRIGHT AND REMAIN THE PROPERTY OF MANTIS DESIGN.
- * ALL BUILDING WORK TO BE EXECUTED ACCORDING TO NATIONAL BUILDING REGULATIONS.
- * ALL DIMENSIONS AND LEVELS TO BE CHECKED ON SITE PRIOR TO CONSTRUCTION.
- * ALL SITE REVISIONS TO BE CONFIRMED WITH MANTIS DESIGN.

PROJECT

**Klein Zevenwacht
Wine and Equestrian Estate**
House Marais R
on Erf 16288 at 9 Brut Close

DRAWING
**WORKING
DRAWINGS**

DESIGN
HJ

DATE
**26 May
2006**

**Electrical Layout:
First Floor**

CHECKED
1:50

REVISION
■

DRAWING NUMBER
M4.05.W-12