


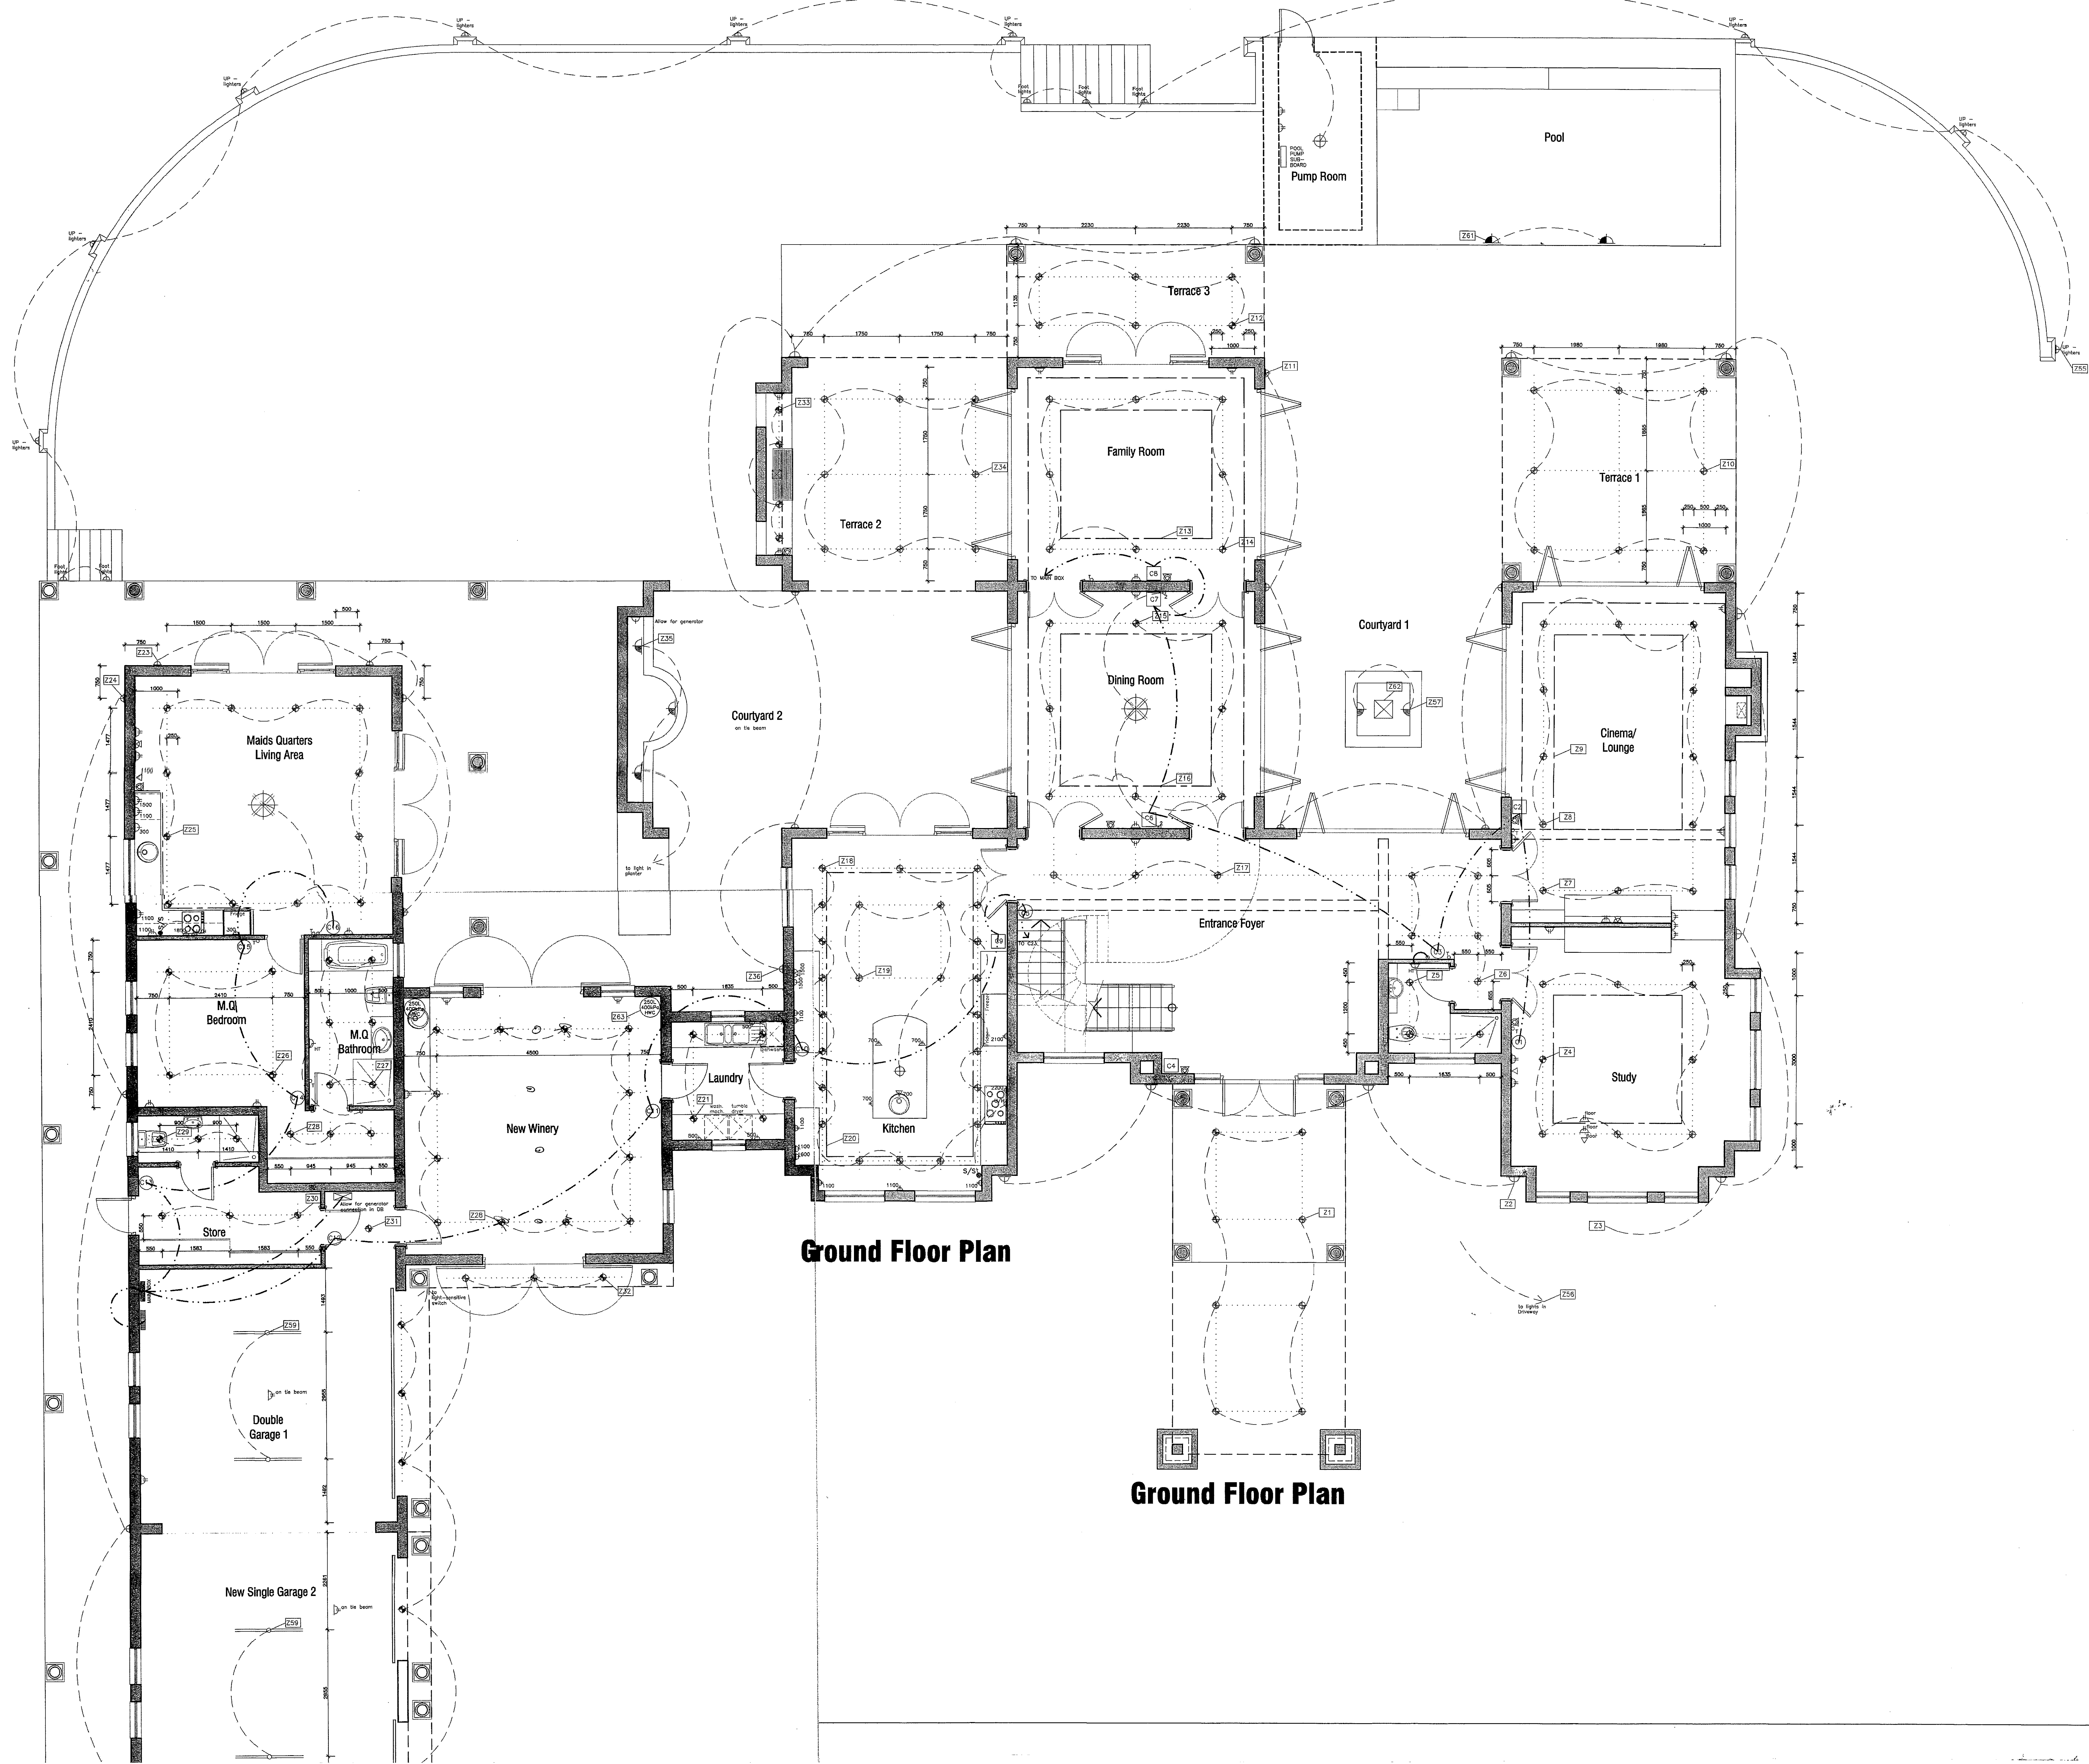


ELECTRICAL SYMBOLS

○	SINGLE LIGHT SWITCH
○ ²	2-WAY LIGHT SWITCH
○ ³	DIMMER SWITCH
○ ^F	FAN RESISTOR SWITCH
○ ^T	THERMOSTAT SWITCH FOR UNDER-TILE/CARPET HEATING
○ ^{S/S}	OVEN AND HOB SWITCH
●	SINGLE PLUG POINT
● ²	SHOWER PLUG POINT
● ³	HEATED TOWEL POINT
● ⁴	DOUBLE PLUG POINT
● ⁵	DEDICATED COMPUTER DOUBLE PLUG
● ⁶	OVEN POINT
● ⁷	HOB POINT
● ⁸	WALL LIGHT
● ⁹	WALL LIGHT WITH LIGHT-SENSITIVE SWITCH
● ¹⁰	POOL LIGHT
● ¹¹	DOUBLE FLOURESCENT LIGHT
● ¹²	CEILING LIGHT
● ¹³	LOW VOLTAGE LIGHT
● ¹⁴	RECESSED LIGHT
● ¹⁵	ALPHONE
● ¹⁶	ALPHONE INTERCOM
● ¹⁷	TELEPHONE POINT
● ¹⁸	TELEVISION POINT
● ¹⁹	CEILING FAN
● ²⁰	DISTRIBUTION BOARD
● ²¹	METER BOARD
● ²²	EXTRACTOR FAN
● ²³	HOTWATER CYLINDER
● ²⁴	CEILING TRAP-DOOR
● ²⁵	ALARM CONTROL PANEL
● ²⁶	ALARM SENSOR
● ²⁷	SPEAKER POINT
● ²⁸	STEP LIGHT
● ²⁹	WATERPROOF LIGHT
● ³⁰	ZONE NUMBER
● ³¹	4x4 CONTROLLER + NUMBER
● ³²	4x2 CONTROLLER + NUMBER

GENERAL NOTES

1. All plug points (u/s of cover plates) to be at 1100mm in kitchen and 250mm in all other rooms unless noted specifically in detail drawings of rooms.
2. Electrical contractor to liaise with client and sub-contractor on final positions of thermostats (floor heating).
3. This drawing to be read in conjunction with Architects instruction working and detail layout drawings.
4. All ground floor external wall-lights mounted at 2100mm off.
5. All electrical wiring (power & light) to be in pvc conduits, and not "urflex", for ease of access and rewiring.

REVISION	DATE	DESCRIPTION
----------	------	-------------

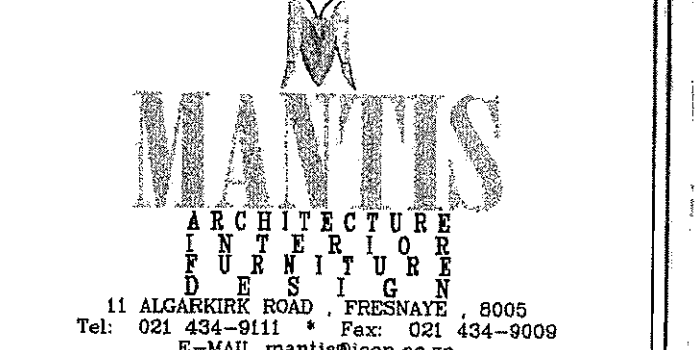

- ALL DRAWINGS ARE COPYRIGHT AND REMAIN THE PROPERTY OF MANTIS DESIGN.
- ALL BUILDING WORK TO BE EXECUTED ACCORDING TO NATIONAL BUILDING REGULATIONS.
- ALL DIMENSIONS AND LEVELS TO BE CHECKED ON SITE PRIOR TO CONSTRUCTION.
- ALL SITE REVISIONS TO BE CONFIRMED WITH MANTIS DESIGN.

PROJECT
Klein Zevenwacht
Wine and Equestrian Estate
 House Jackson
 on Erf 16321 at 41 Heerengracht Close

WORKING DRAWINGS	SEAL	DATE
Electrical Layout: Ground Floor	LavdM	1. Aug. 2006
	SCALE	1:50
	REVISION	E

DRAWING NUMBER
J1.04.W-10