


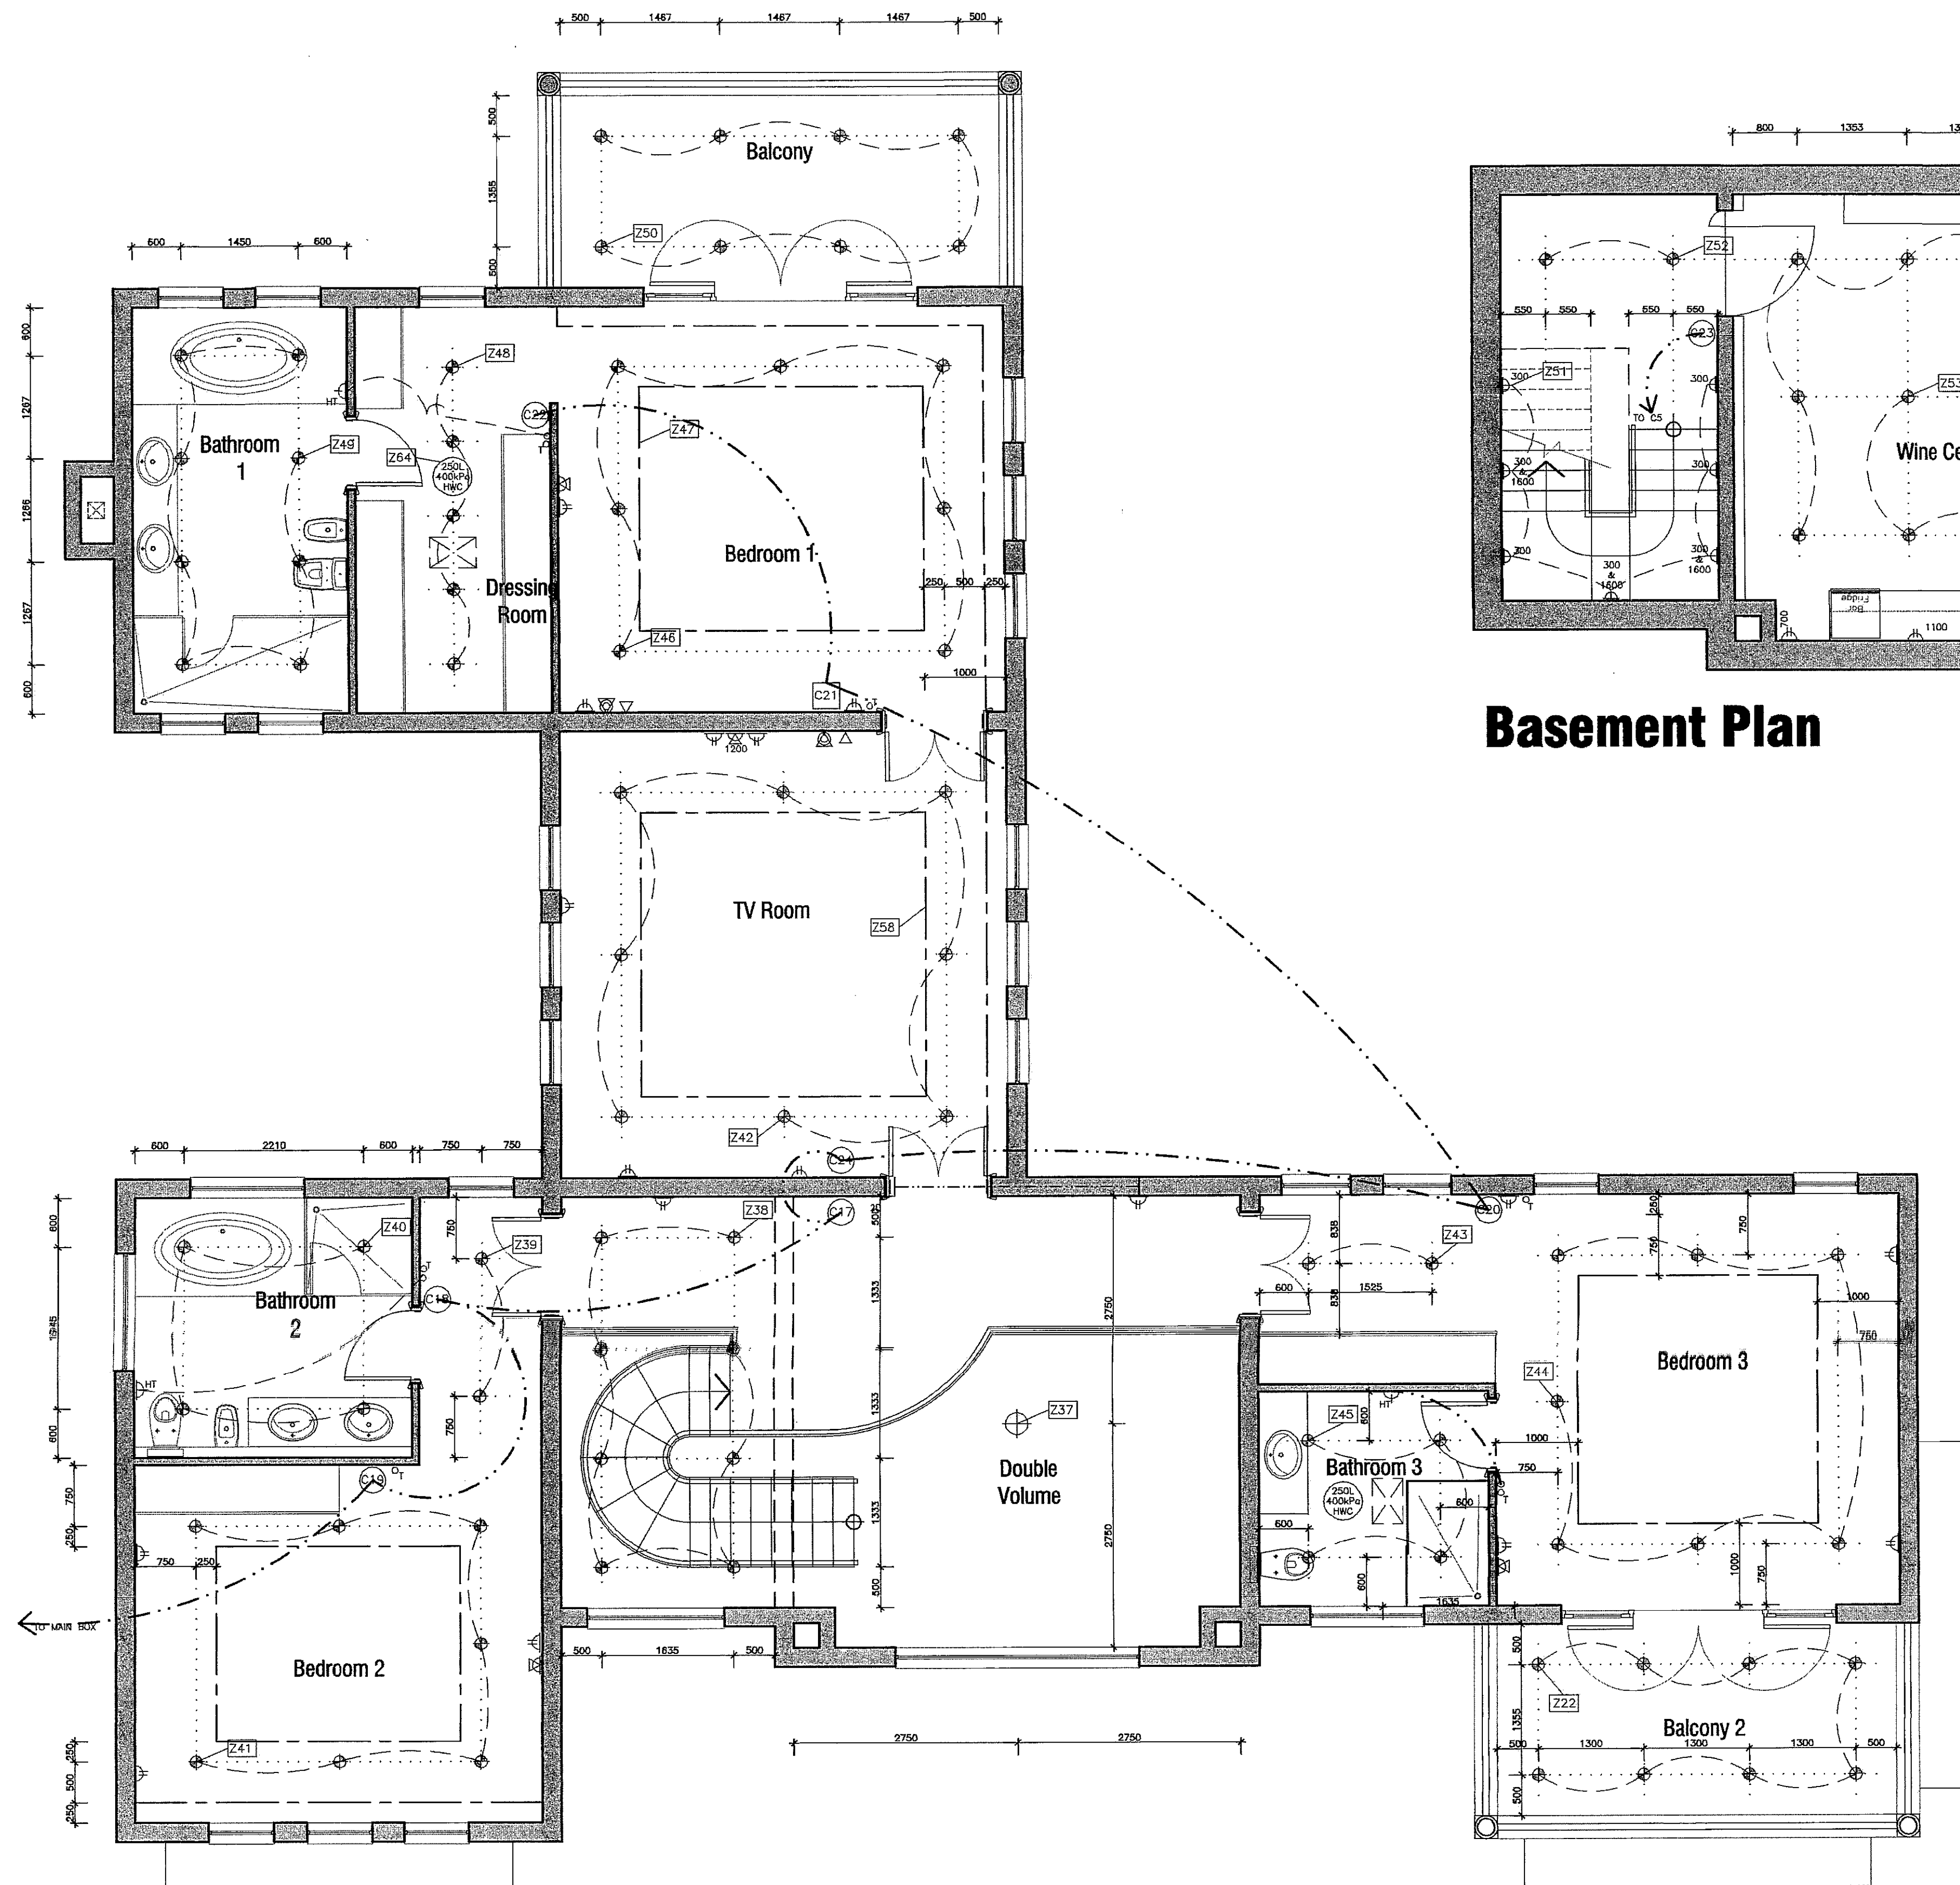

First Floor Plan

Basement Plan

ELECTRICAL SYMBOLS

○	SINGLE LIGHT SWITCH
○ ²	2-WAY LIGHT SWITCH
○ ^D	DIMMER SWITCH
○ ^F	FAN RESISTOR SWITCH
○ ^T	THERMOSTAT SWITCH FOR UNDER-TILE/CARPET HEATING
○ ^{S/S}	OVEN AND HOB SWITCH
⌋	SINGLE PLUG POINT
⌋ ^S	SHAVER PLUG POINT
⌋ ^{HT}	HEATED TOWEL POINT
⌋ ^D	DOUBLE PLUG POINT
⌋ ^{DC}	DEDICATED COMPUTER DOUBLE PLUG
⌋ ^U	OVEN POINT
⌋ ^H	HOB POINT
⌋ ^{LS}	WALL LIGHT
⌋ ^{LS}	WALL LIGHT WITH LIGHT-SENSITIVE SWITCH
⌋ ^{PL}	POOL LIGHT
⌋ ^{DF}	DOUBLE FLOURESCENT LIGHT
⌋ ^{CL}	CEILING LIGHT
⌋ ^{LV}	LOW VOLTAGE LIGHT
⌋ ^{RL}	RECESSED LIGHT
⌋ ^{AP}	AIPHONE
⌋ ^{AI}	AIPHONE INTERCOM
⌋ ^{TP}	TELEPHONE POINT
⌋ ^{TV}	TELEVISION POINT
⌋ ^{CF}	CEILING FAN
⌋ ^{DB}	DISTRIBUTION BOARD
⌋ ^{MB}	METER BOARD
⌋ ^{EX}	EXTRACTOR FAN
⌋ ^{HWC}	HOTWATER CYLINDER
⌋ ^{CTD}	CEILING TRAP-DOOR
⌋ ^{ACP}	ALARM CONTROL PANEL
⌋ ^{AS}	ALARM SENSOR
⌋ ^{SP}	SPEAKER POINT
⌋ ^{SL}	STEP LIGHT
⌋ ^{WL}	WATERPROOF LIGHT
⌋ ^{Z??}	ZONE NUMBER
⌋ ^{CP?}	4x4 CONTROLLER + NUMBER
⌋ ^{CP?}	4x2 CONTROLLER + NUMBER

REVISION	DATE	DESCRIPTION

MANTIS
ARCHITECTURE
INTERIOR
DESIGN
11 ALGARBIER ROAD, TRESNATE, 8005
Tel: 021 434-8111 • Fax: 021 434-8009
E-MAIL: mantis@icon.co.za

- ALL DRAWINGS ARE COPYRIGHT AND REMAIN THE PROPERTY OF MANTIS DESIGN.
- ALL BUILDING WORK TO BE EXECUTED ACCORDING TO NATIONAL BUILDING REGULATIONS.
- ALL DIMENSIONS AND LEVELS TO BE CHECKED ON SITE PRIOR TO CONSTRUCTION.
- ALL SITE REVISIONS TO BE CONFIRMED WITH MANTIS DESIGN.

Klein Zevenwacht
Wine and Equestrian Estate
House Jackson
on Erf 16321 at 41 Heerengracht Close

DRAWING WORKING DRAWINGS	DRAWN LavdM	DATE 1 Aug. 2006
Electrical Layout: First Floor Basement	CHECKED SCALE 1:50	REVISION E

DRAWING NUMBER
J1.04.W-11